

FLOOR PLAN GENERAL NOTES


- ALL BLOCKING AND WOOD MEMBERS TO BE FIRE RETARDANT TREATED. PROVIDE PRESSURE IMPREGNATION WITH FIRE RETARDANT CHEMICALS TO PROVIDE U.L. F.R.S. FIRE HAZARD CLASSIFICATION. ALL WOOD SHALL BE IDENTIFIED WITH A U.L. LABEL CERTIFYING THIS CLASSIFICATION.
- APPROVED FIRE EXTINGUISHERS SHALL BE FURNISHED, LOCATED AND INSTALLED BY THE GENERAL CONTRACTOR AS REQUIRED BY THE GOVERNING AUTHORITY. REFER TO SHEET A-113 FOR FINISH PLAN.
- REFER TO SHEET A-121 FOR REFLECTED CEILING PLAN. REFER TO SHEET A-601 FOR WALL TYPES AND DOOR SCHEDULES.

SYMBOL LEGEND


- EXISTING PARTITIONS / WALLS TO REMAIN
- NEW FRAME PARTITIONS
- NEW FRAME PARTITIONS TO DECK
- NEW LOW WALL PARTITIONS
- BATT INSULATION
- WALL TYPES - REFER TO SHEET A-601 FOR ADDITIONAL INFORMATION
- DOOR TAG, REFER A-601 FOR SCHEDULE AND ADDITIONAL NOTES

FLOOR PLAN KEYNOTES

| KEYNOTE | DESCRIPTION |
|---------|--|
| 01 | IT/DATA RACK, REF. ELECTRICAL, DATA AND ELECTRICAL OUTLETS TO BE INSTALLED AT 90" A.F.F. COORDINATE WITH OWNER'S LOW VOLTAGE VENDOR. |
| 02 | LOW WALL 2X6 MTL. STUD FRAME WITH BRACING AT EA. END, EA. CORNER, AND EVERY 48" O.C. MAX., REF. DET 61A-601 |
| 03 | FURNITURE BY OWNER |
| 04 | ELECTRICAL TRANSFORMER AND PANELS, REF. ELECTRICAL |
| 05 | FACP PANEL |
| 06 | 48" VINYL COATED CHAINLINK FENCE WITH FLOOR-MOUNTED SUPPORT POSTS |
| 06A | COURT ENTRY GATE AND SIDE PANEL, FURNISHED BY OWNER, INSTALLED BY CONTRACTOR |
| 07 | EXISTING COLUMN TO REMAIN, TYP. @ GRID LINES |
| 08 | COURT SURFACE BY OWNER'S VENDOR, COORDINATE WITH RELATED WORK |
| 09 | EXISTING SPRINKLER RISER AND FIRE DEPARTMENT CONNECTION TO REMAIN, VERIFY ACCESS REQUIREMENTS WITH LOCAL FIRE MARSHAL. |
| 10 | DECORATIVE MILLWORK WALL, INSTALL OVER FINISHED WALL AND VINYL BASE. |
| 11 | LED ENTRY SIGN, PROVIDE VENTILATED WALL BOX FOR LOW VOLTAGE DRIVER |
| 12 | ROOF DRAIN ADJACENT TO COLUMN, PAINT EXPOSED DRAINPIPES P12. |

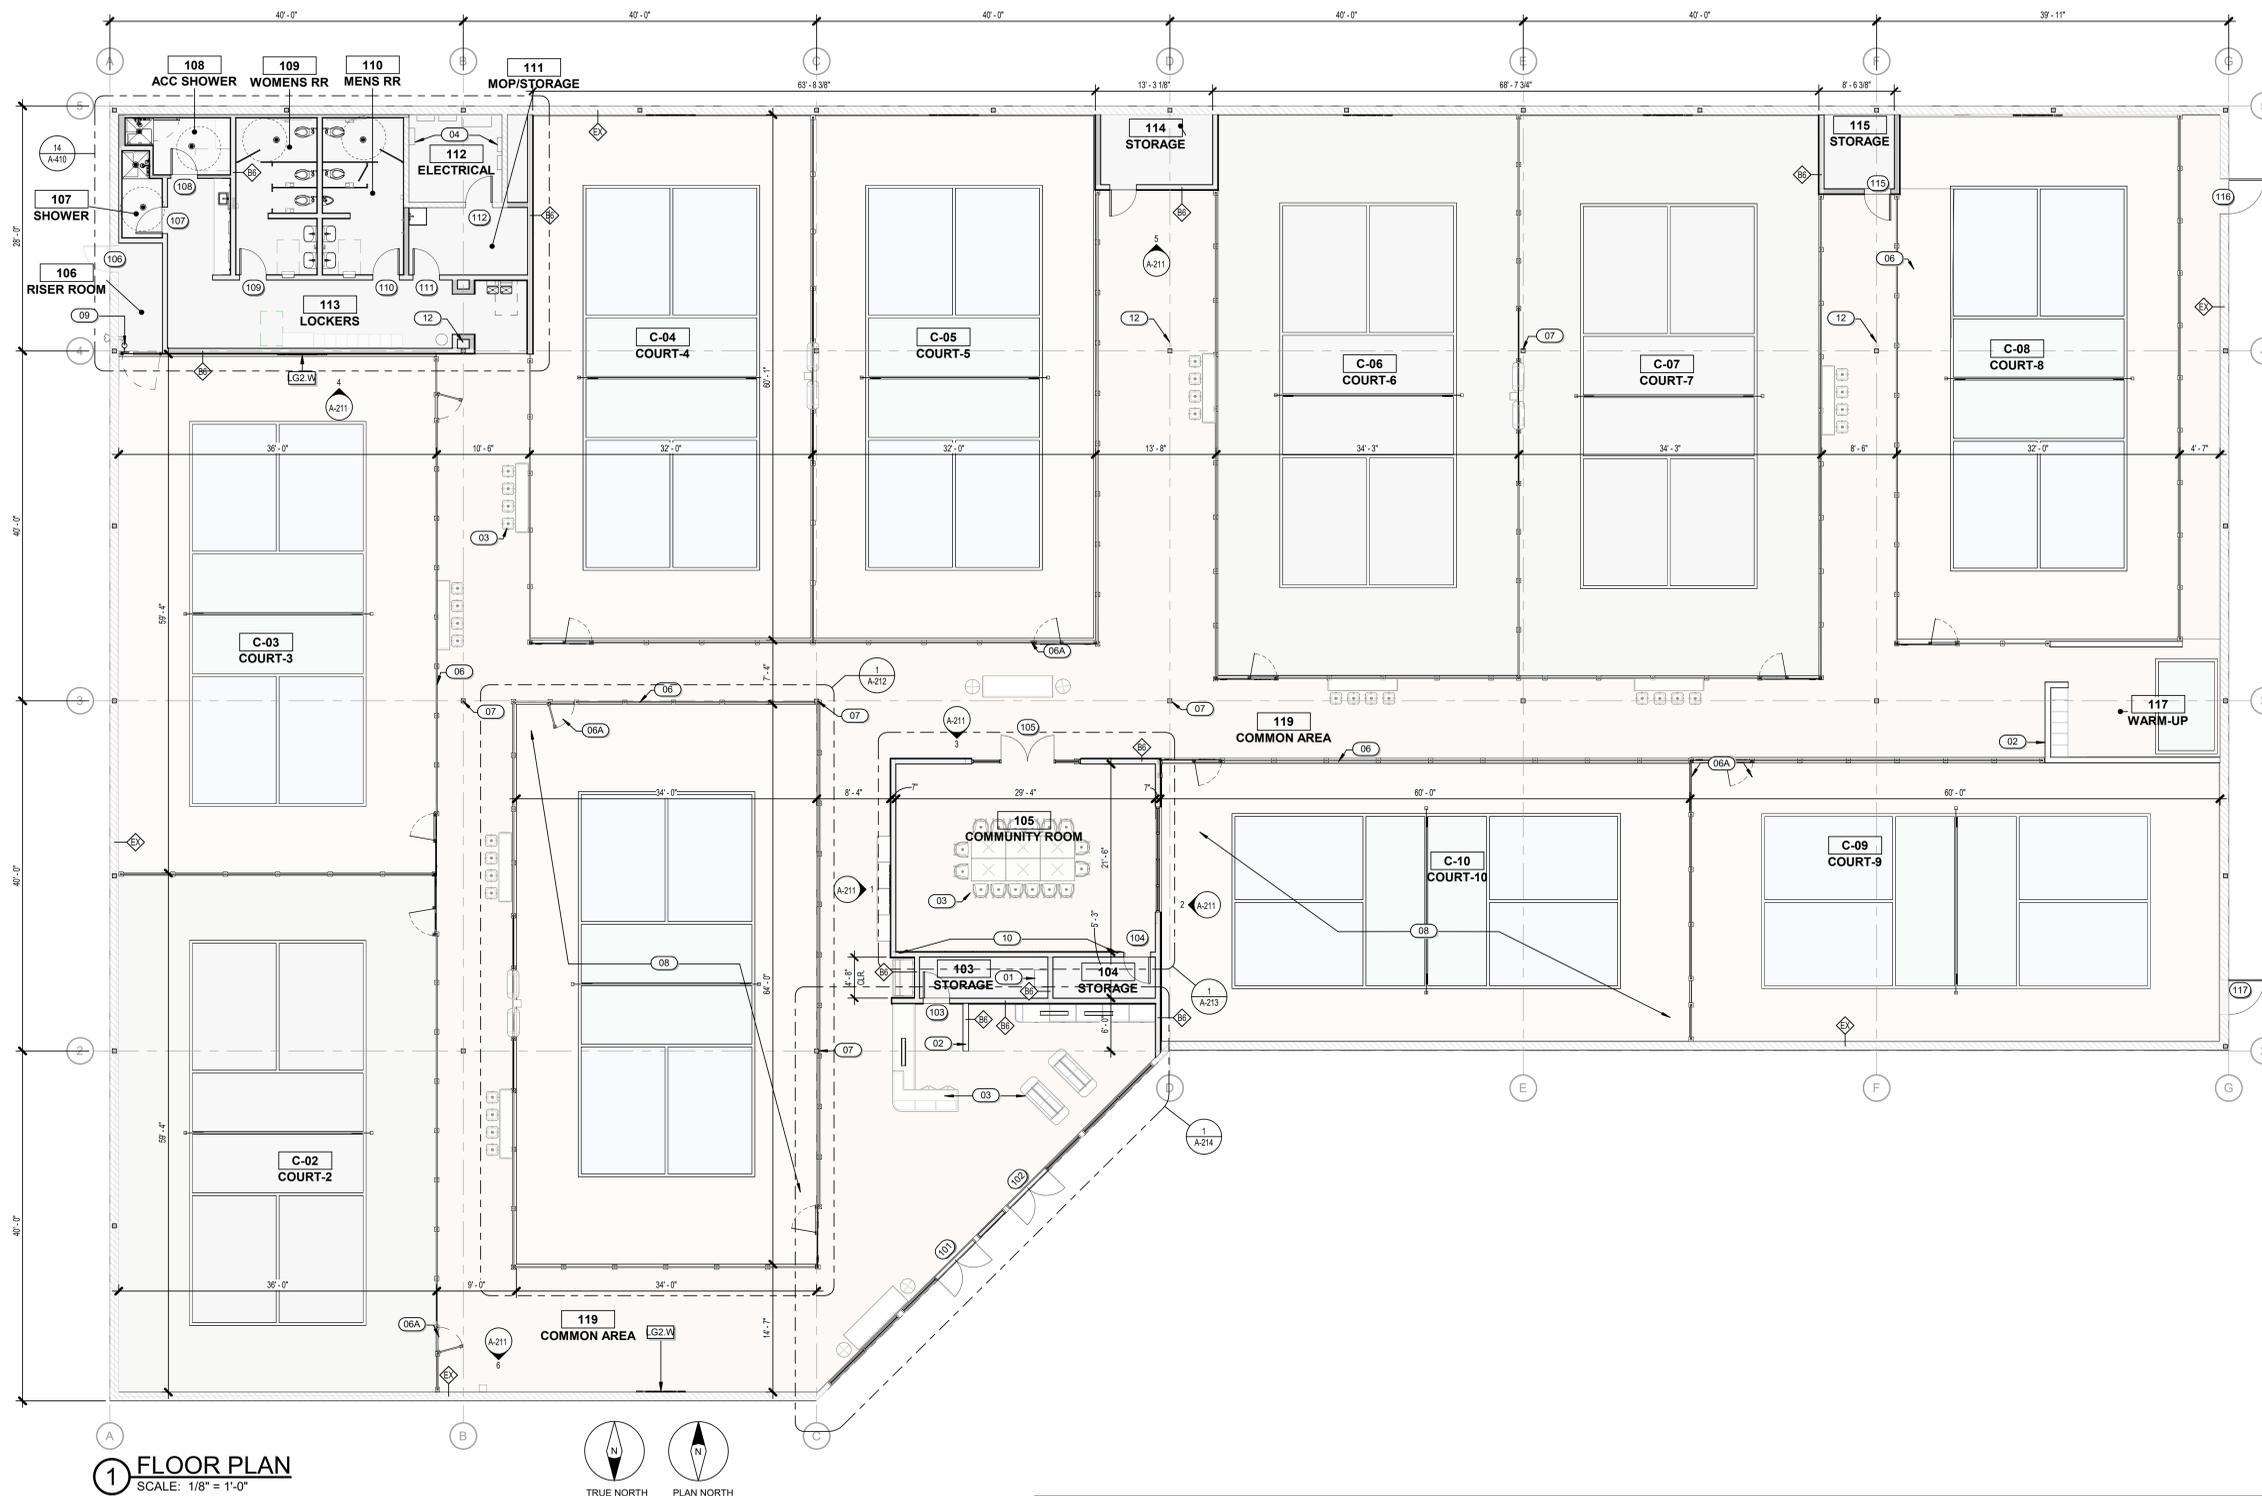

1 FLOOR PLAN
SCALE: 1/8" = 1'-0"

 

APPLIANCE AND SIGNAGE SCHEDULE

| AP | APPLIANCES | MATERIAL | MANUFACTURER | STYLE | SIZE | COLOR | NOTES | VENDOR REQUIRED | FURNISH/INSTALL |
|-----------------------------|------------------------------|--|------------------------|-----------------------|--------------------|-------|---|--|-----------------|
| AP1 | DISPLAY GRAB N' GO | | TURBO AIR REFRIGERATOR | Turbo Air TOM-60DXB-N | 60"W X 79"H X 37"D | | Requires power per Spec + EOR, see plan for unit location | | OF/CI |
| AP2 | Court Cleaning Machine | Walk-behind floor cleaner | TENNANT | | | | Stored within proximity of the court areas Roughly 54" L x 22" W x 43" H Provide standard outlet for charging onboard lithium battery when not in use | Tennant Order direct from manufacturer via Pickl'r Portal | OF/CI |
| AP3 | BALL MACHINE | BALL MACHINE | ERNE BALL MACHINE | | | | Stored within proximity of the court areas Provide standard duplex outlet for charging when not in use | Erne Order direct from manufacturer via Pickl'r Portal | OF/CI |
| SIGNAGE + WAYFINDING | | | | | | | | | |
| GR | GRAPHICS | | | | | | | | |
| GR1 | BRANDED WINDOW VINYL | Branded Window Vinyl, Translucent and Opaque available | | | | | | FUSION Katie Foster 801.586.4912 katie.foster@fusionimaging.com www.fusionimaging.com | OF/CI |
| LG | LOGO | | | | | | | | |
| LG1 | LOGO AT NET | FELT LOGO ATTACHED TO CENTER COURT NET | J2 | | | | Order through Pickl'r + J2 Systems Order form in PICKL'R Library | J2 Systems Mark Hollingshead p. 801.701.7979 m. 801.897.3216 mark@j2systems.net http://www.j2systems.net/ | OF/CI |
| LG2.W | LOGO AT COURT WALL | MILLED WOOD LOGO MOUNTED TO WALL | FUSION | | | | Order through Pickl'r + Fusion Portal (SEE FUSION WELCOME LETTER) | FUSION | OF/CI |
| LG3 | LOGO AT FRONT DESK | MILLED WOOD LOGO MOUNTED TO WALL | FUSION | | | | | | OF/CI |
| SG | SIGNAGE | | | | | | | | |
| SG1 | NUMBER AT ENTRY COURT PORTAL | | | | | | | J2 Systems | OF/CI |
| SG2.W | ILLUMINATED ENTRY SIGN | Milled wood + Lighting element, located per plan | | | | | Bottom aligned to 2' AFF Typ. | J2 Systems | OF/CI |